



6/16/22
P. 287


This design or drawing is the sole property of Calamba Water District. No part of this design or drawing may be reproduced or transmitted in any form or by any means without the written consent of its owner.

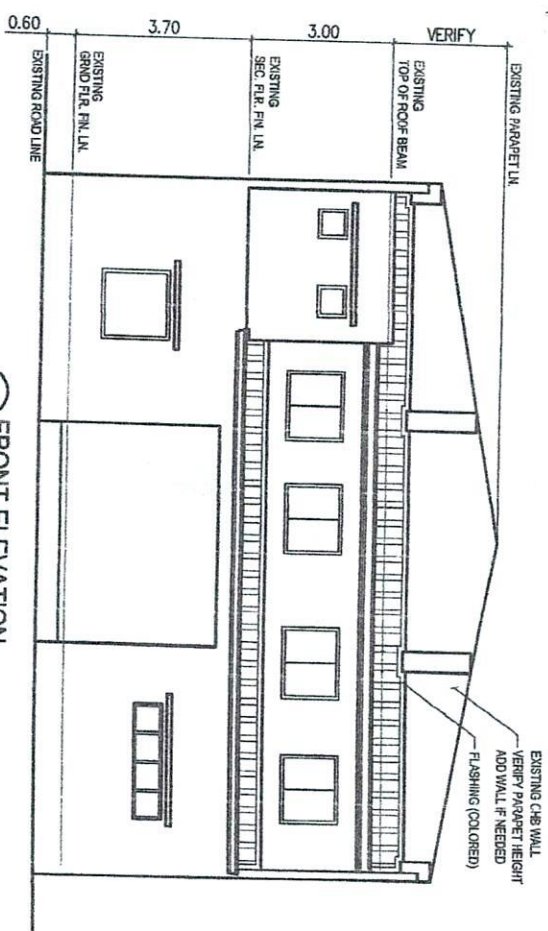


FRONT ELEVATION
SCALE 1:100 m

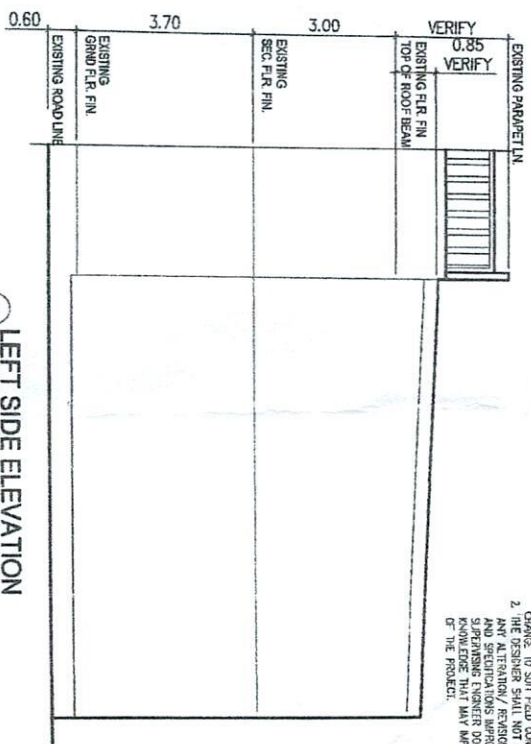

LEFT SIDE ELEVATION
SCALE 1:100 m

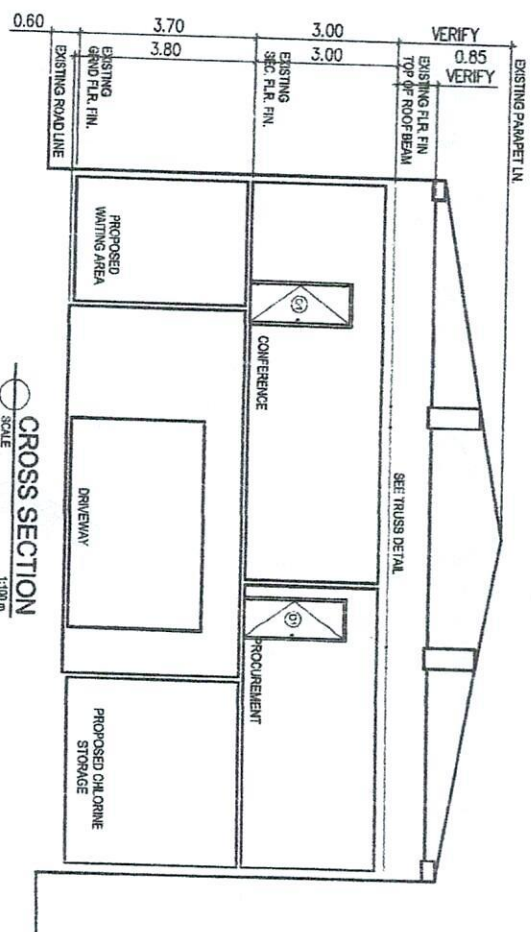

CROSS SECTION
SCALE 1:100 m

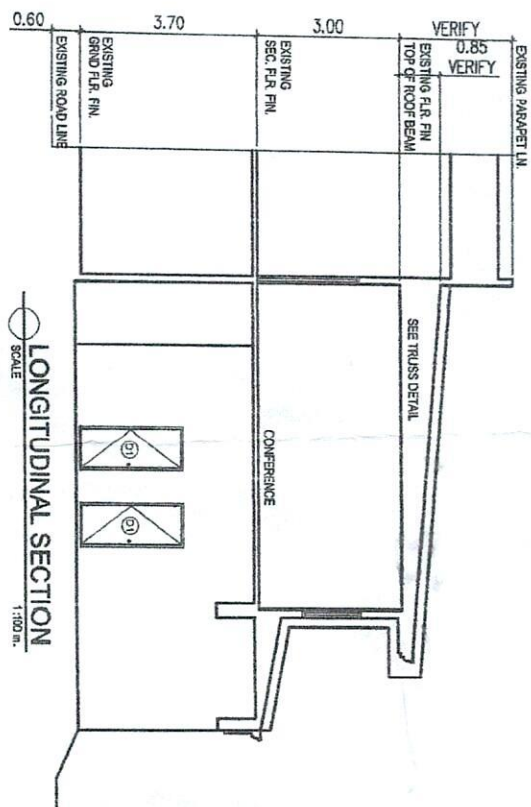

LONGITUDINAL SECTION
SCALE 1:100 m

- NOTES: SIZES AND LOCATIONS ARE SUBJECT TO CHANGE TO SUIT FIELD CONDITIONS. THE DESIGNER SHALL NOT BE LIABLE FOR ANY ALTERATION/REVISION ON THE PLANS/DRAWINGS AND SPECIFICATIONS APPROVED BY THE ENGINEER/ARCHITECT. THE ENGINEER/ARCHITECT SHALL BE RESPONSIBLE FOR THE KNOWLEDGE THAT MAY AFFECT THE THOUGHT OF THE PROJECT.



TECHNICAL SERVICES DEPARTMENT
ENGINEERING AND MAINTENANCE DIVISION

PROJECT TITLE:

RENOVATION OF 2ND FLOOR CEILING OF MAIN WAREHOUSE BLDG,
LABOR AND MATERIALS FOR THE PLASTERING & WATERPROOFING OF
WALL AT MAIN WAREHOUSE BLDG

LOCATION: LAKEVIEW SUBD., BRGY. HALANG, CALAMBA, LAGUNA

DRAWN & DESIGNED BY: ENGR. ALBERTO

CHECKED BY: ENGR. MD. A.C. ANILANOSA

RECOMMENDED BY: ENGR. R. CORTADO

APPROVED BY: MR. E. A. AGUILAR, JR.

SHEET CONTENTS:

AS SHOWN

DATE: 08/11/2025

SHEET NO.

REVISION NO.

2

2/2

REF. NO. CWD-QF-TS-EMD-004

Revision No.: 01

EFFECTIVITY DATE: May 17, 2022


2F WAREHOUSE

PROJECT TITLE:

RENOVATION
LABOR AND M



LOCATION: LAKE

This design or drawing is the sole property of Calamba Water District. No part of this design or drawing may be reproduced or transmitted in any form or by any means without the written consent of its owner.

 

CALAMBA WATER DISTRICT
Laguayan Subdivision, Haling, Calamba City, Laguna
Tel Nos. 545-1014, 545-2643, 545-2726, 545-2995, Fax No. 545-2712
WWW.CWD.CITY LGU

**TECHNICAL SERVICES DEPARTMENT
ENGINEERING AND MAINTENANCE DIVISION**

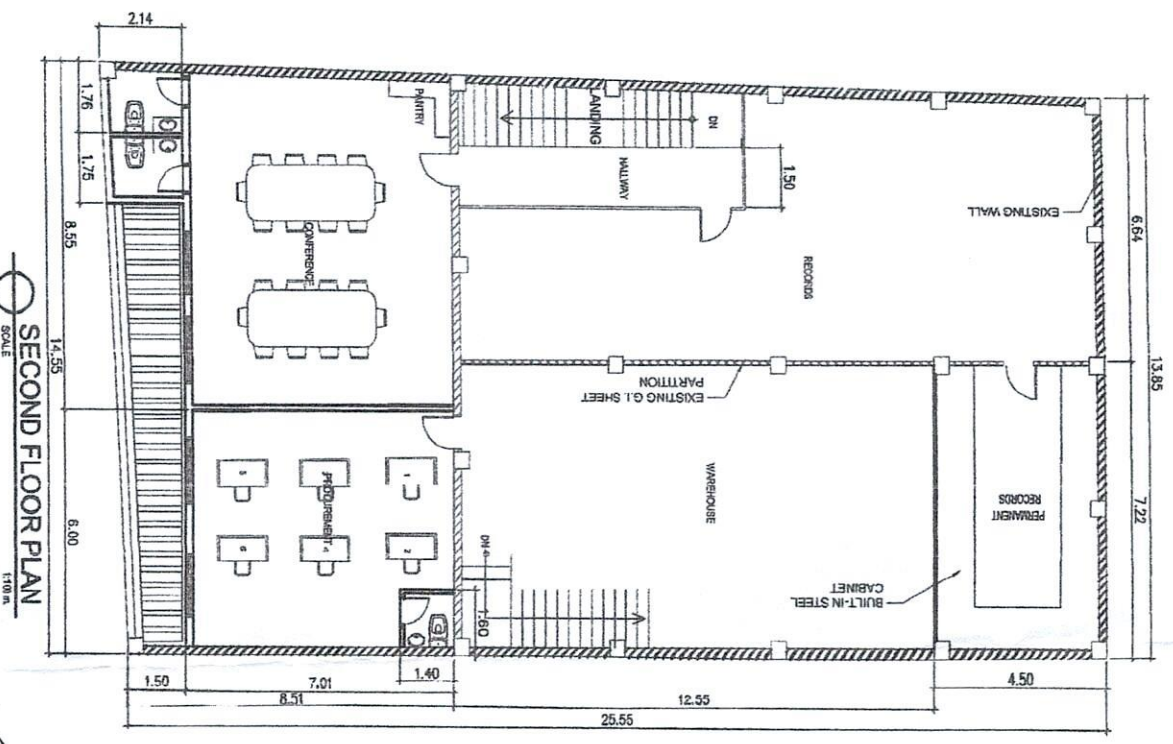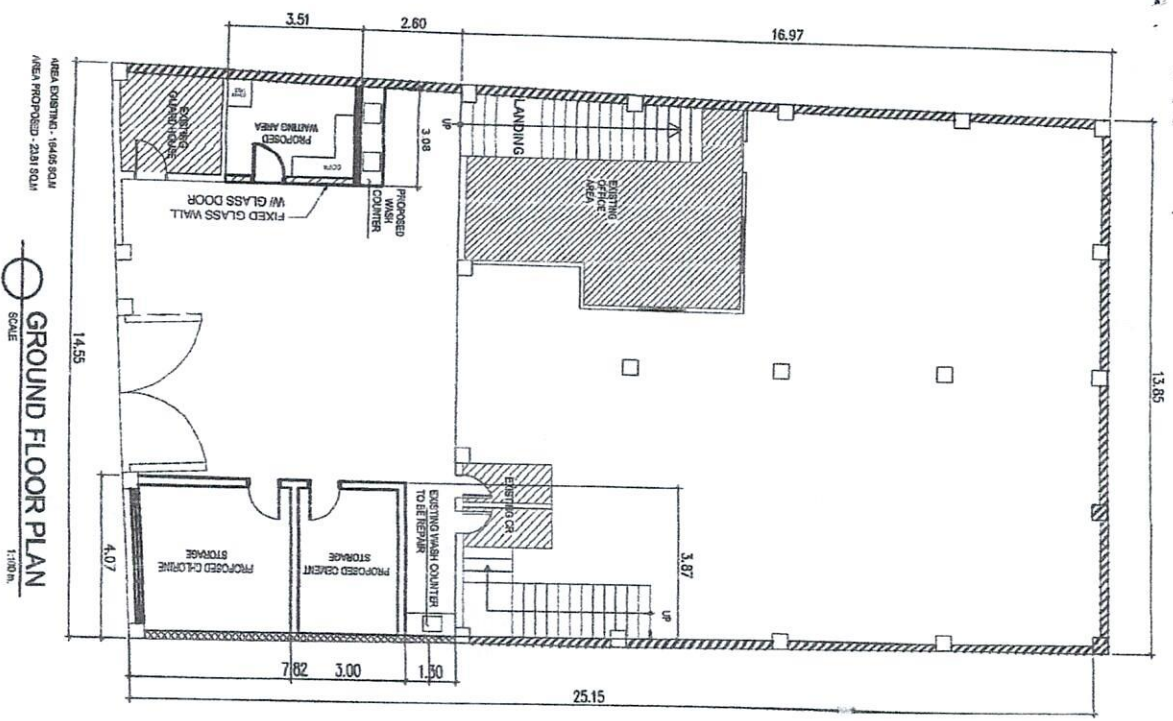

LEGEND:
EXISTING EXTERIOR WALL
TO BE WATERPROOFED

- NOTES:
1. ALL SIZES AND LOCATIONS ARE SUBJECT TO CHANGE TO SUIT FIELD CONDITIONS.
 2. ANY ALTERATION/REVISION IN THE PLANS/DRAWINGS AND SPECIFICATIONS APPROVED BY THE AUTHORIZED SUPERVISING ENGINEER DO NOT WITHIN THEIR KNOWLEDGE THAT MAY AFFECT THE STRENGTH OF THE PROJECT.

PROJECT TITLE:	DRAWN & DESIGNED BY:	SHEET CONTENTS:	DATE:
RENOVATION OF 2ND FLOOR CEILING OF MAIN WAREHOUSE BLDG, LABOR AND MATERIALS FOR THE PLASTERING & WATERPROOFING OF WALL AT MAIN WAREHOUSE BLDG	ENGR. J.C. AUBUTO		06/11/2025
LOCATION: LAKEVIEW SUBD., BRGY. HALANG, CALAMBA, LAGUNA	CHECKED BY: ENGR. No. A. C. VILLANOSA	SHEET NO.	
	RECOMMENDED BY: ENGR. R. CARIAG	AS SHOWN	
	APPROVED BY: MR. E. A. AGUILAR, JR.	REVISION NO.	1/1
		2	

ELEVATION
1:100

FINAL SECTION
1:100

\$: AUBUTO	SHEET
VILLANOSA	AS
RINGO	REVISION
R. R. R.	



2/2


EFFECTIVITY DATE: May 17, 2022




CALAMBA WATER DISTRICT
Laborer's Subdivision, Hiligaynon, Calamba City, Laguna
Tel. Nos. 546-1646; 546-2728; 546-7895; Fax No. 546-9732
WWW.CWD.5001PH

TECHNICAL SERVICES DEPARTMENT
ENGINEERING AND MAINTENANCE DIVISION

2F REFLECTED CEILING PLAN

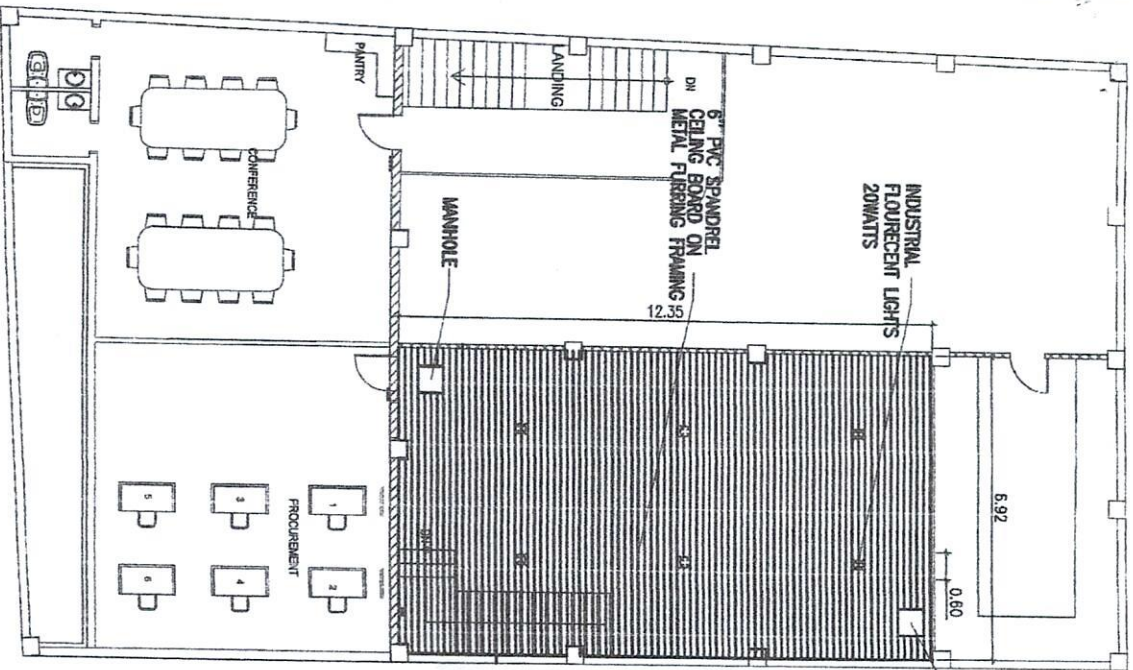

2F WAREHOUSE ELECTRICAL PLAN

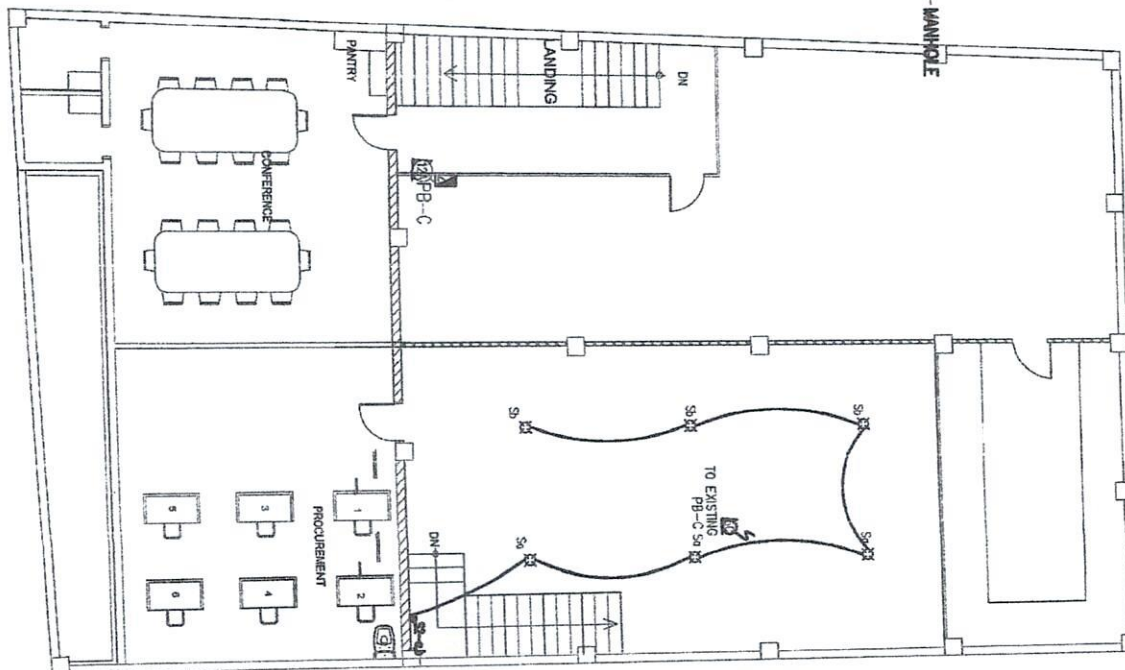


EXISTING SCHEDULE OF LOADS (PB-C)				
CRT. NO.	DESCRIPTION	WATTS	VOLTS	BREAKER
1C	B-100w LIGHT BULB	800	230	2P-15A,230V
2C	3-PHASE OUTLET	1080	230	2P-15A,230V
3C	3-PHASE OUTLET	1080	230	2P-15A,230V
4C	HOST MOTOR	2880	230	2P-30A,230V
5C	B-100w LIGHT BULB	800	230	2P-15A,230V
TOTAL		6540	230	2P-40A,230V

A= 37800x93x1.25
230
A= 33.56A (USE 2-8.0mm THIN
5.5mm THIN GROUNDING
IN 25mm PVC PIPE)

PROPOSED SCHEDULE OF LOADS (PB-C)				
CRT. NO.	DESCRIPTION	WATTS	VOLTS	BREAKER
1C	B-100w LIGHT BULB	800	230	2P-15A,230V
2C	3-PHASE OUTLET	1080	230	2P-15A,230V
3C	3-PHASE OUTLET	1080	230	2P-15A,230V
4C	HOST MOTOR	2880	230	2P-30A,230V
5C	B-100w LIGHT BULB	800	230	2P-15A,230V
TOTAL		6540	230	2P-40A,230V

A= 6040x93x1.25
230
A= 30.52A (USE 2-8.0mm THIN
5.5mm THIN GROUNDING
IN 25mm PVC PIPE)

DETAIL OF PANELBOARD-C (PB-C)
SF RECORDS

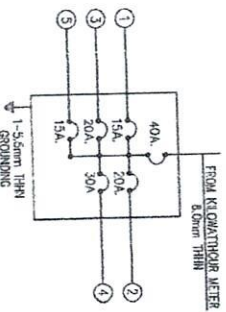

- NOTES:
1. ALL SIZES AND LOCATIONS ARE SUBJECT TO CHANGE TO SUIT FIELD CONDITIONS.
 2. THE DESIGNER SHALL NOT BE LIABLE FOR ANY ALTERATION/REVISION OF THE PLANS/DRAWINGS AND SPECIFICATIONS MADE BY THE AUTHORIZED PERSONNEL AND/OR FIELD PERSONNEL WITHOUT THEIR KNOWLEDGE THAT MAY AFFECT THE STRENGTH OF THE PROJECT.

DRAWN & DESIGNED BY: ENGR. J.C. MABUTO

CHECKED BY: ENGR. M. A. C. AVILA

RECOMMENDED BY: ENGR. R. CARTAGNO

APPROVED BY: MR. E. A. AGUILAR

SHEET CONTENTS:

DATE: 06/11/2025

SHEET NO.

REVISION NO.

EFFECTIVITY DATE: May 17, 2022